



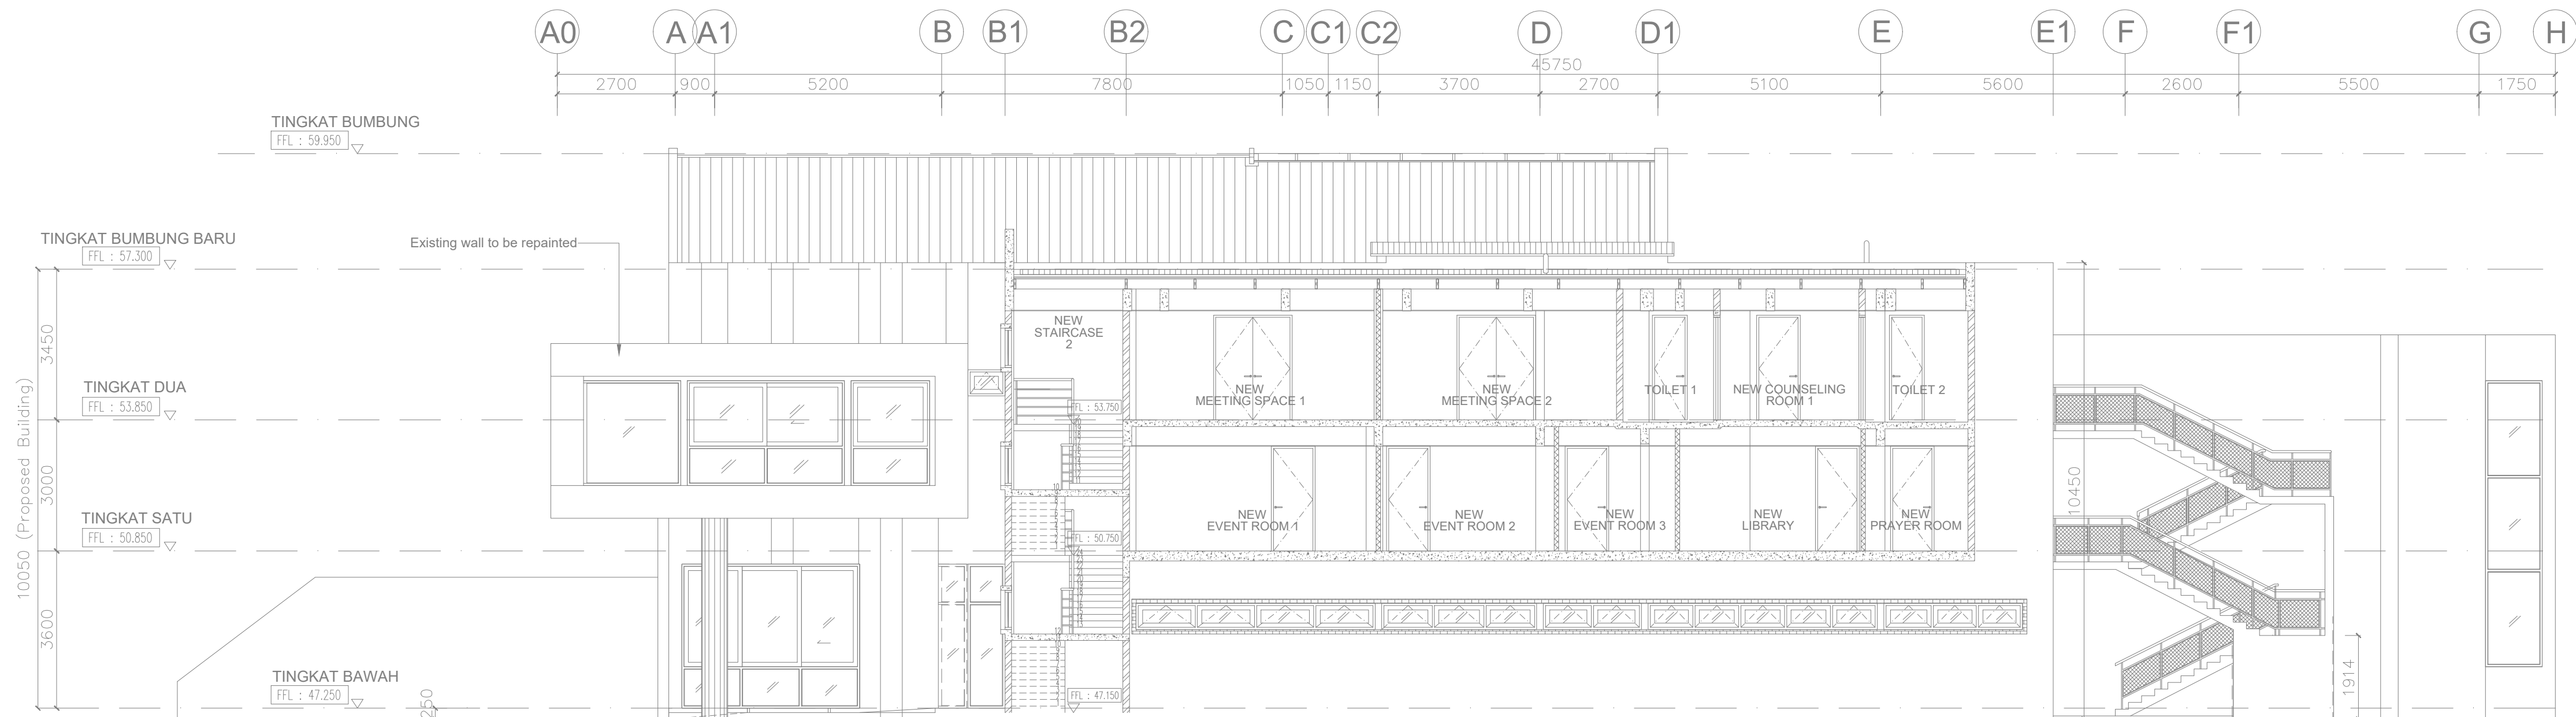

SECTION Y1-Y1

SCALE = 1 : 200 (A3)

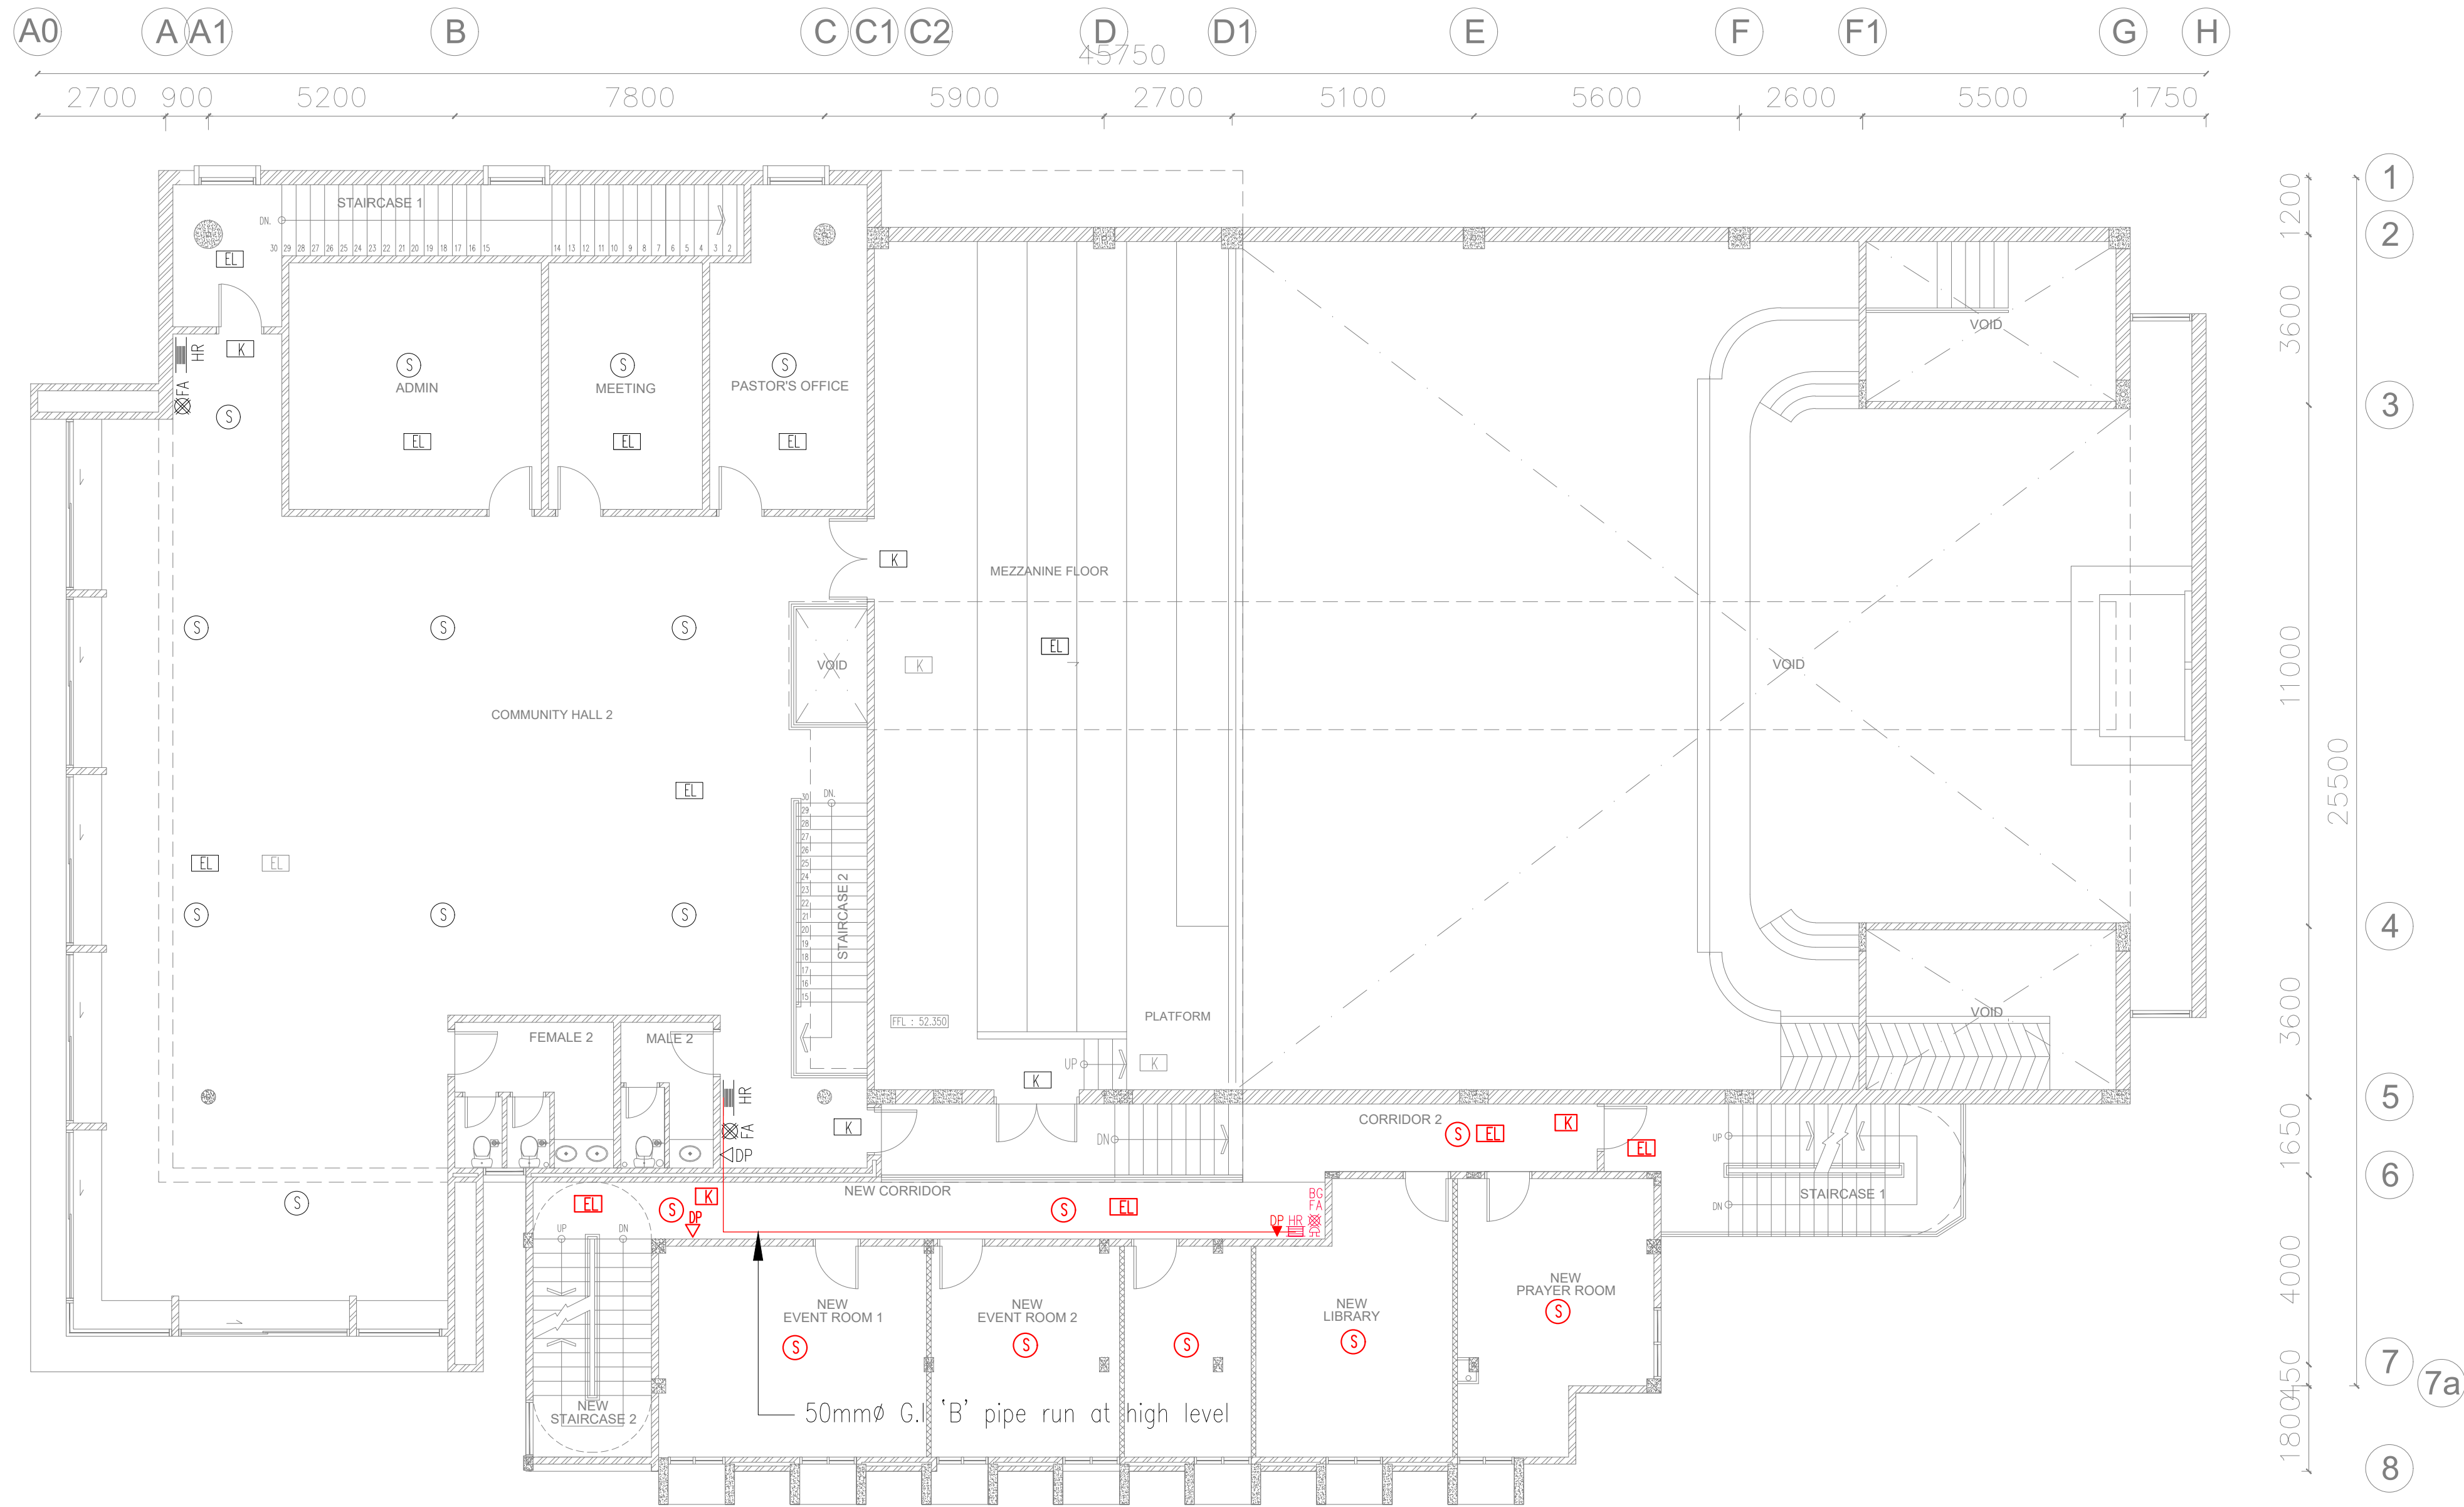

FIRST FLOOR PLAN

SCALE 1 : 200 (A3)

AS BUILT DRAWING
APRIL 2023

MAIN CONTRACTOR :
NSK Construction & Engineering Sdn. Bhd.
B-2-6, BBT One Boulevard
Lebuhraya Batu Nilam 2, Bandar Bukit Tinggi,
41200 Klang, Selangor Darul Ehsan,
Tel : +603-3325 2328 / 2628
Fax : +603-3325 2168
E-mail: enquiry@nskce.com

Tajuk Lukisan :
FIRST FLOOR PLAN
FIRE PROTECTION SYSTEM LAYOUT

Tarikh : April 2023	Dilukis Oleh : Teoh
Ukuran : 1 : 100	Disemak Oleh : Ng
Projek No: JCY/18043/FF-02	Bil. Lukisan : -