


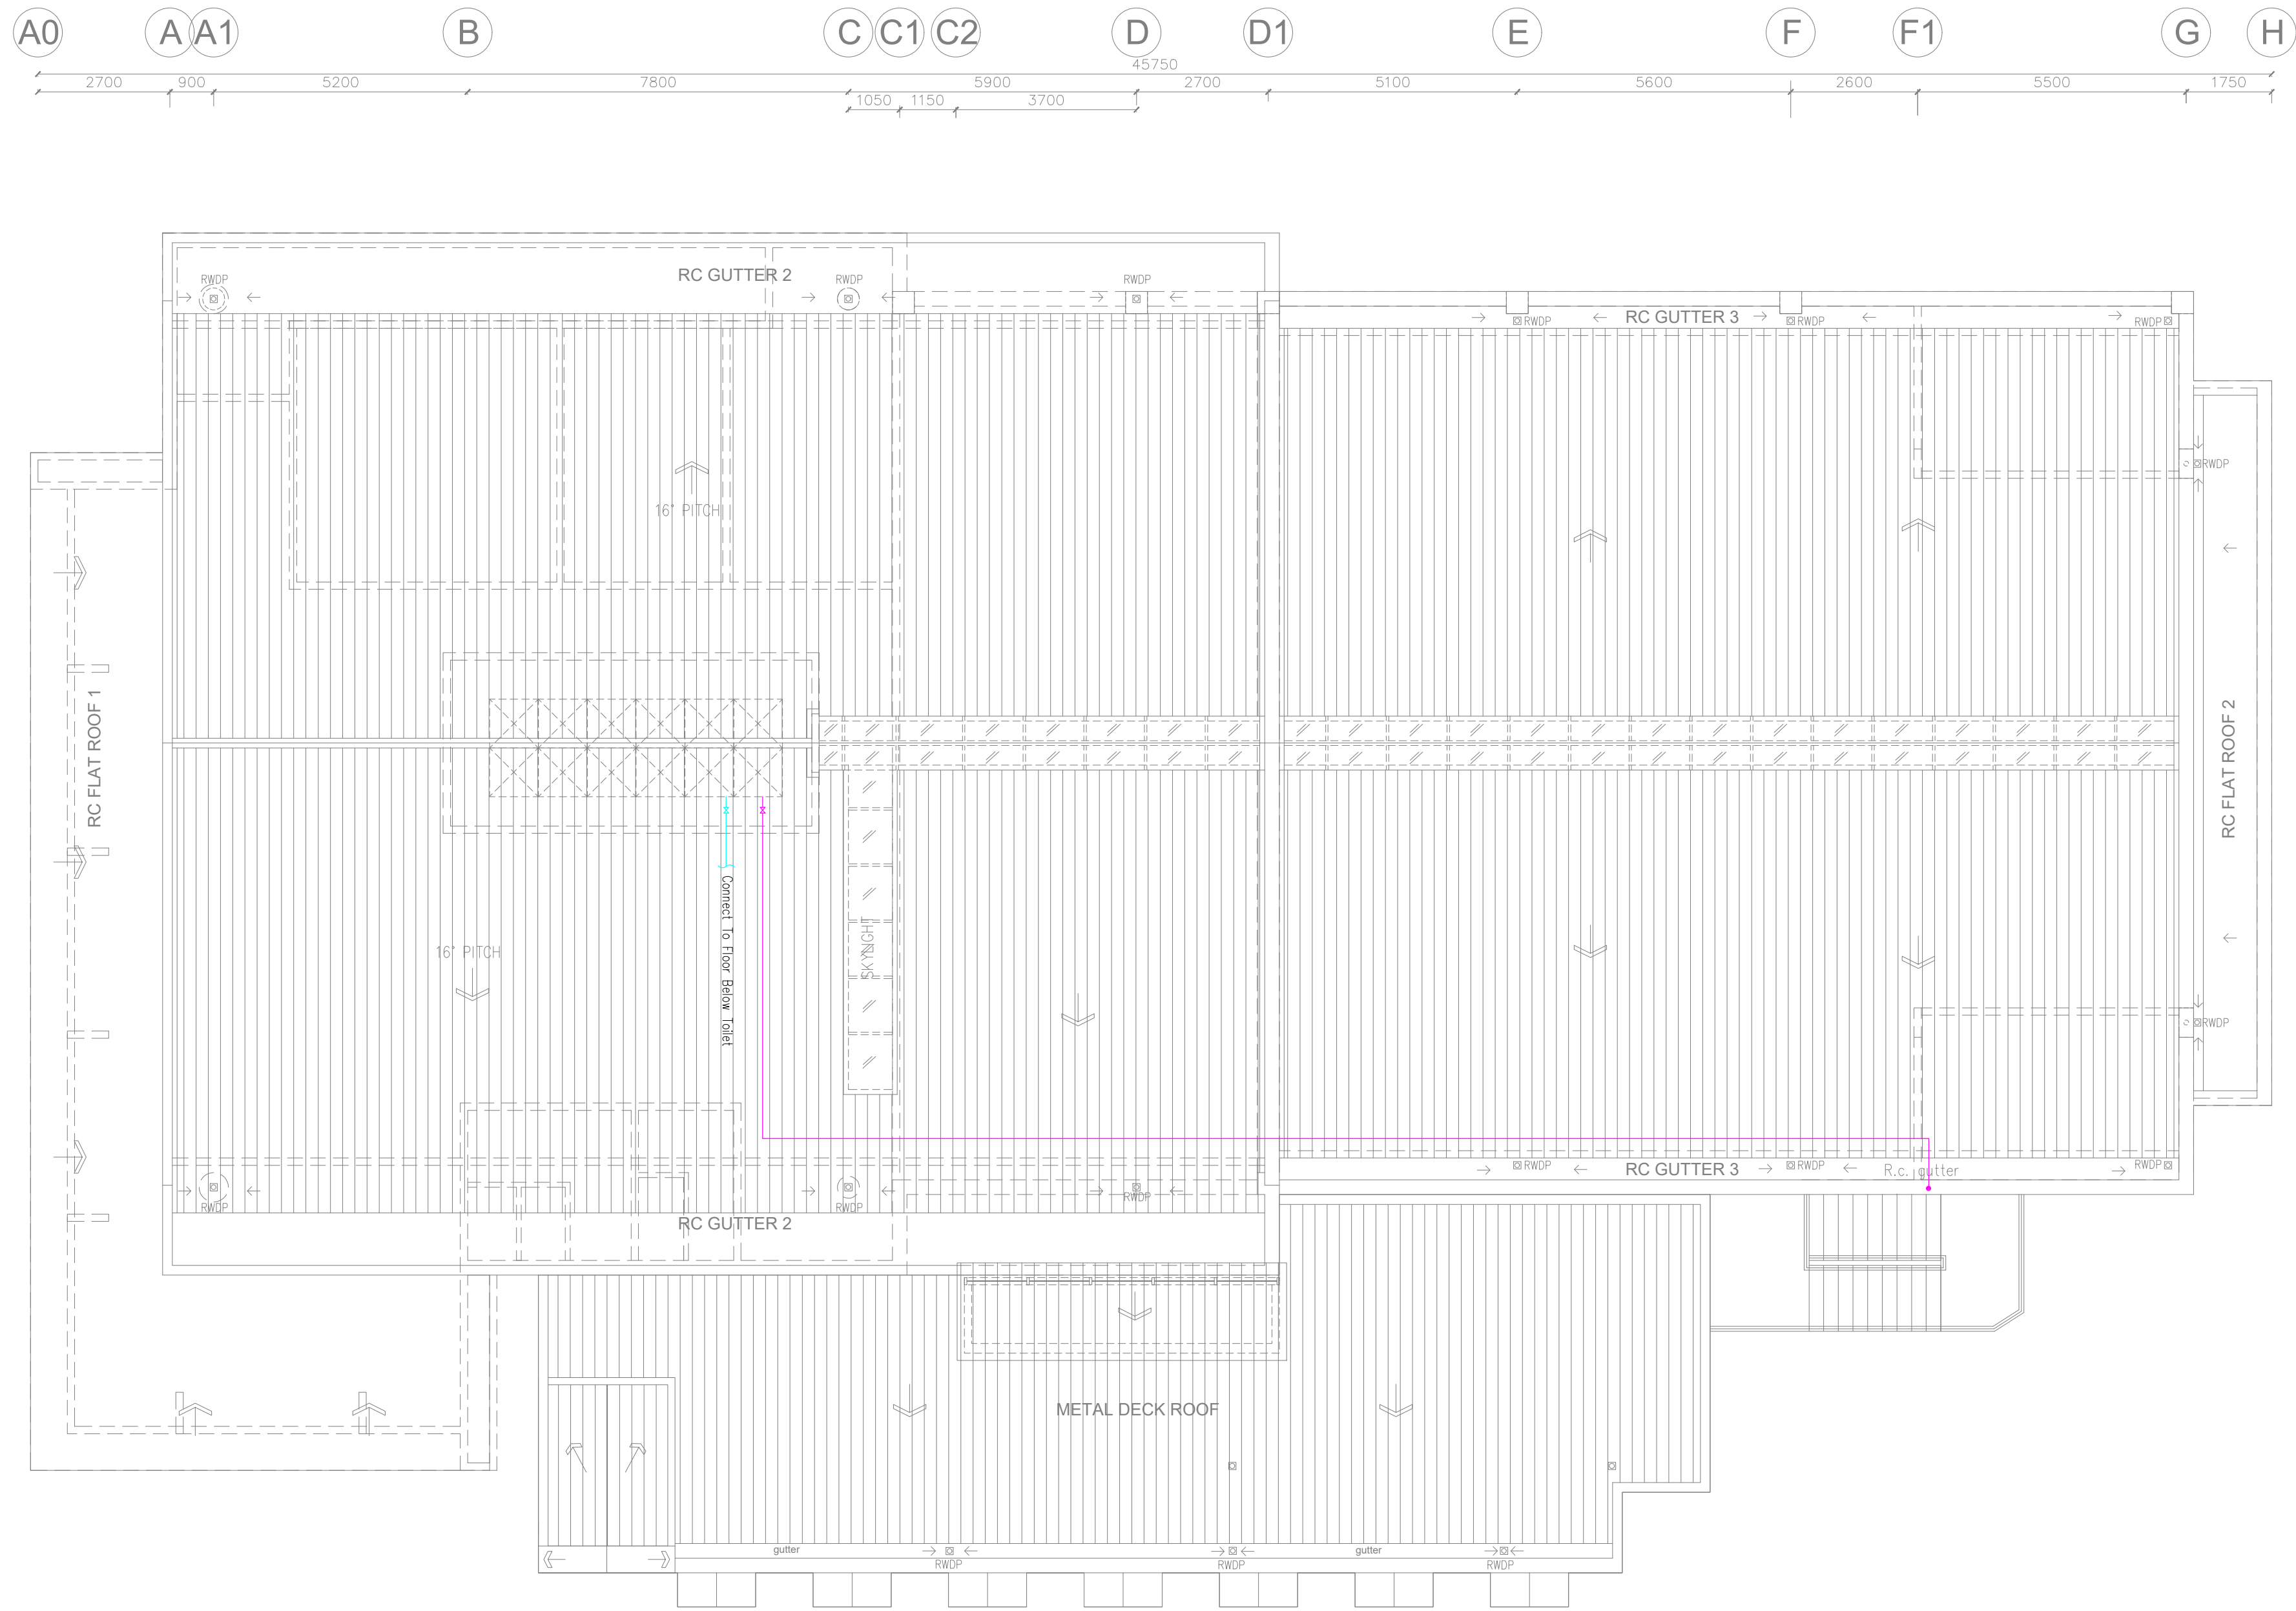

ROOF PLAN

SCALE 1 : 200 (A3)

MAIN CONTRACTOR :			
NSK Construction & Engineering Sdn. Bhd.			
B-2-6, BBT One Boulevard Lembuh Batu Nilam 2, Bandar Bukit Tinggi, 41200 Klang, Selangor Darul Ehsan. Tel : +603-3325 2328 / 2628 Fax : +603-3325 2168 E-mail: enquiry@nskce.com			
Tajuk Lukisan :			
ROOF PLAN			
COLD WATER PIPING LAYOUT			
Tarikh :	April 2023	Dilukis Oleh :	Teoh
Ukuran :	1 : 200 (A3)	Disemak Oleh :	Ng
Projek No: JCY/18043/CW-04			Bil. Lukisan : -

AS BUILT DRAWING
APRIL 2023