


86° 57' 40" 83.804

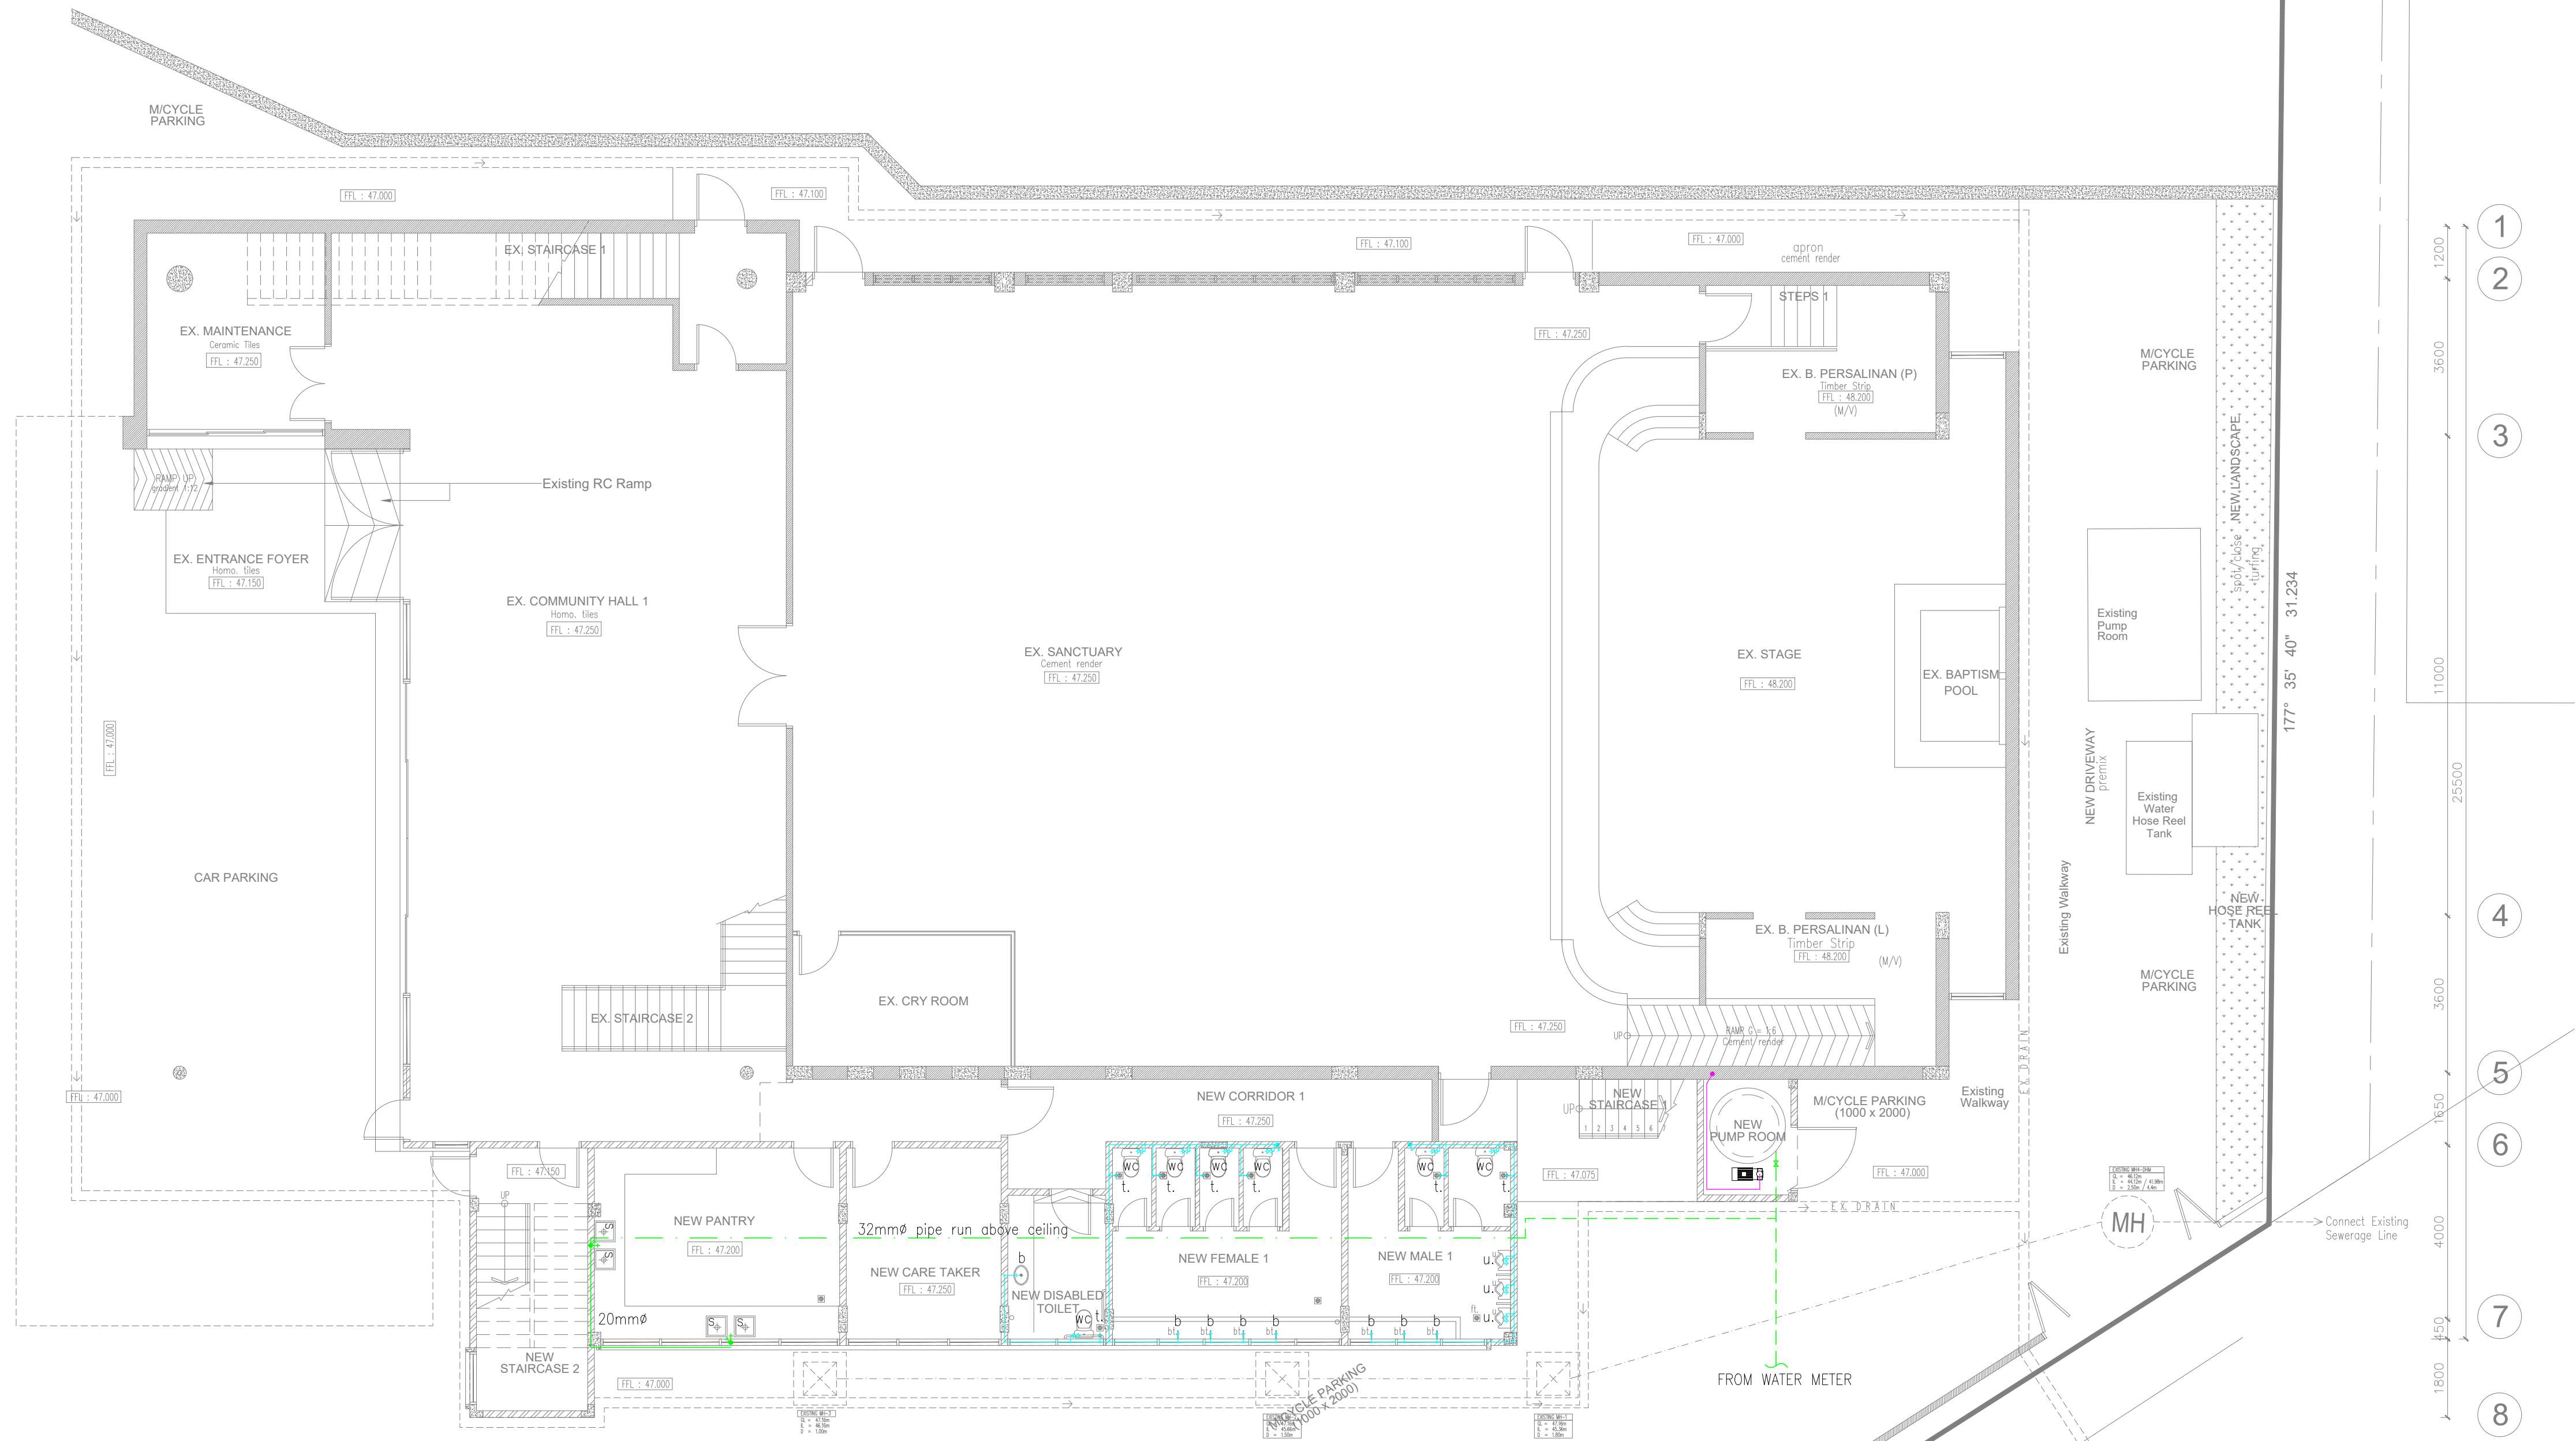

GROUND FLOOR PLAN

SCALE 1 : 200 (A3)

AS BUILT DRAWING
APRIL 2023

MAIN CONTRACTOR :
NSK Construction & Engineering Sdn. Bhd.
B-2-6, BBT One Boulevard
Lebuhr Batu Nilam 2, Bandar Bukit Tinggi,
41200 Klang, Selangor Darul Ehsan.
Tel : +603-3325 2328 / 2626
Fax : +603-3325 2168
E-mail: enquiry@nskce.com

Tajuk Lukisan :
GROUND FLOOR PLAN
COLD WATER PIPING LAYOUT

Tarikh : April 2023 Dilukis Oleh : Teoh

Ukuran : 1 : 200 (A3) Disemak Oleh : Ng

Projek No: JCY/18043/CW-01 Bil. Lukisan : -