


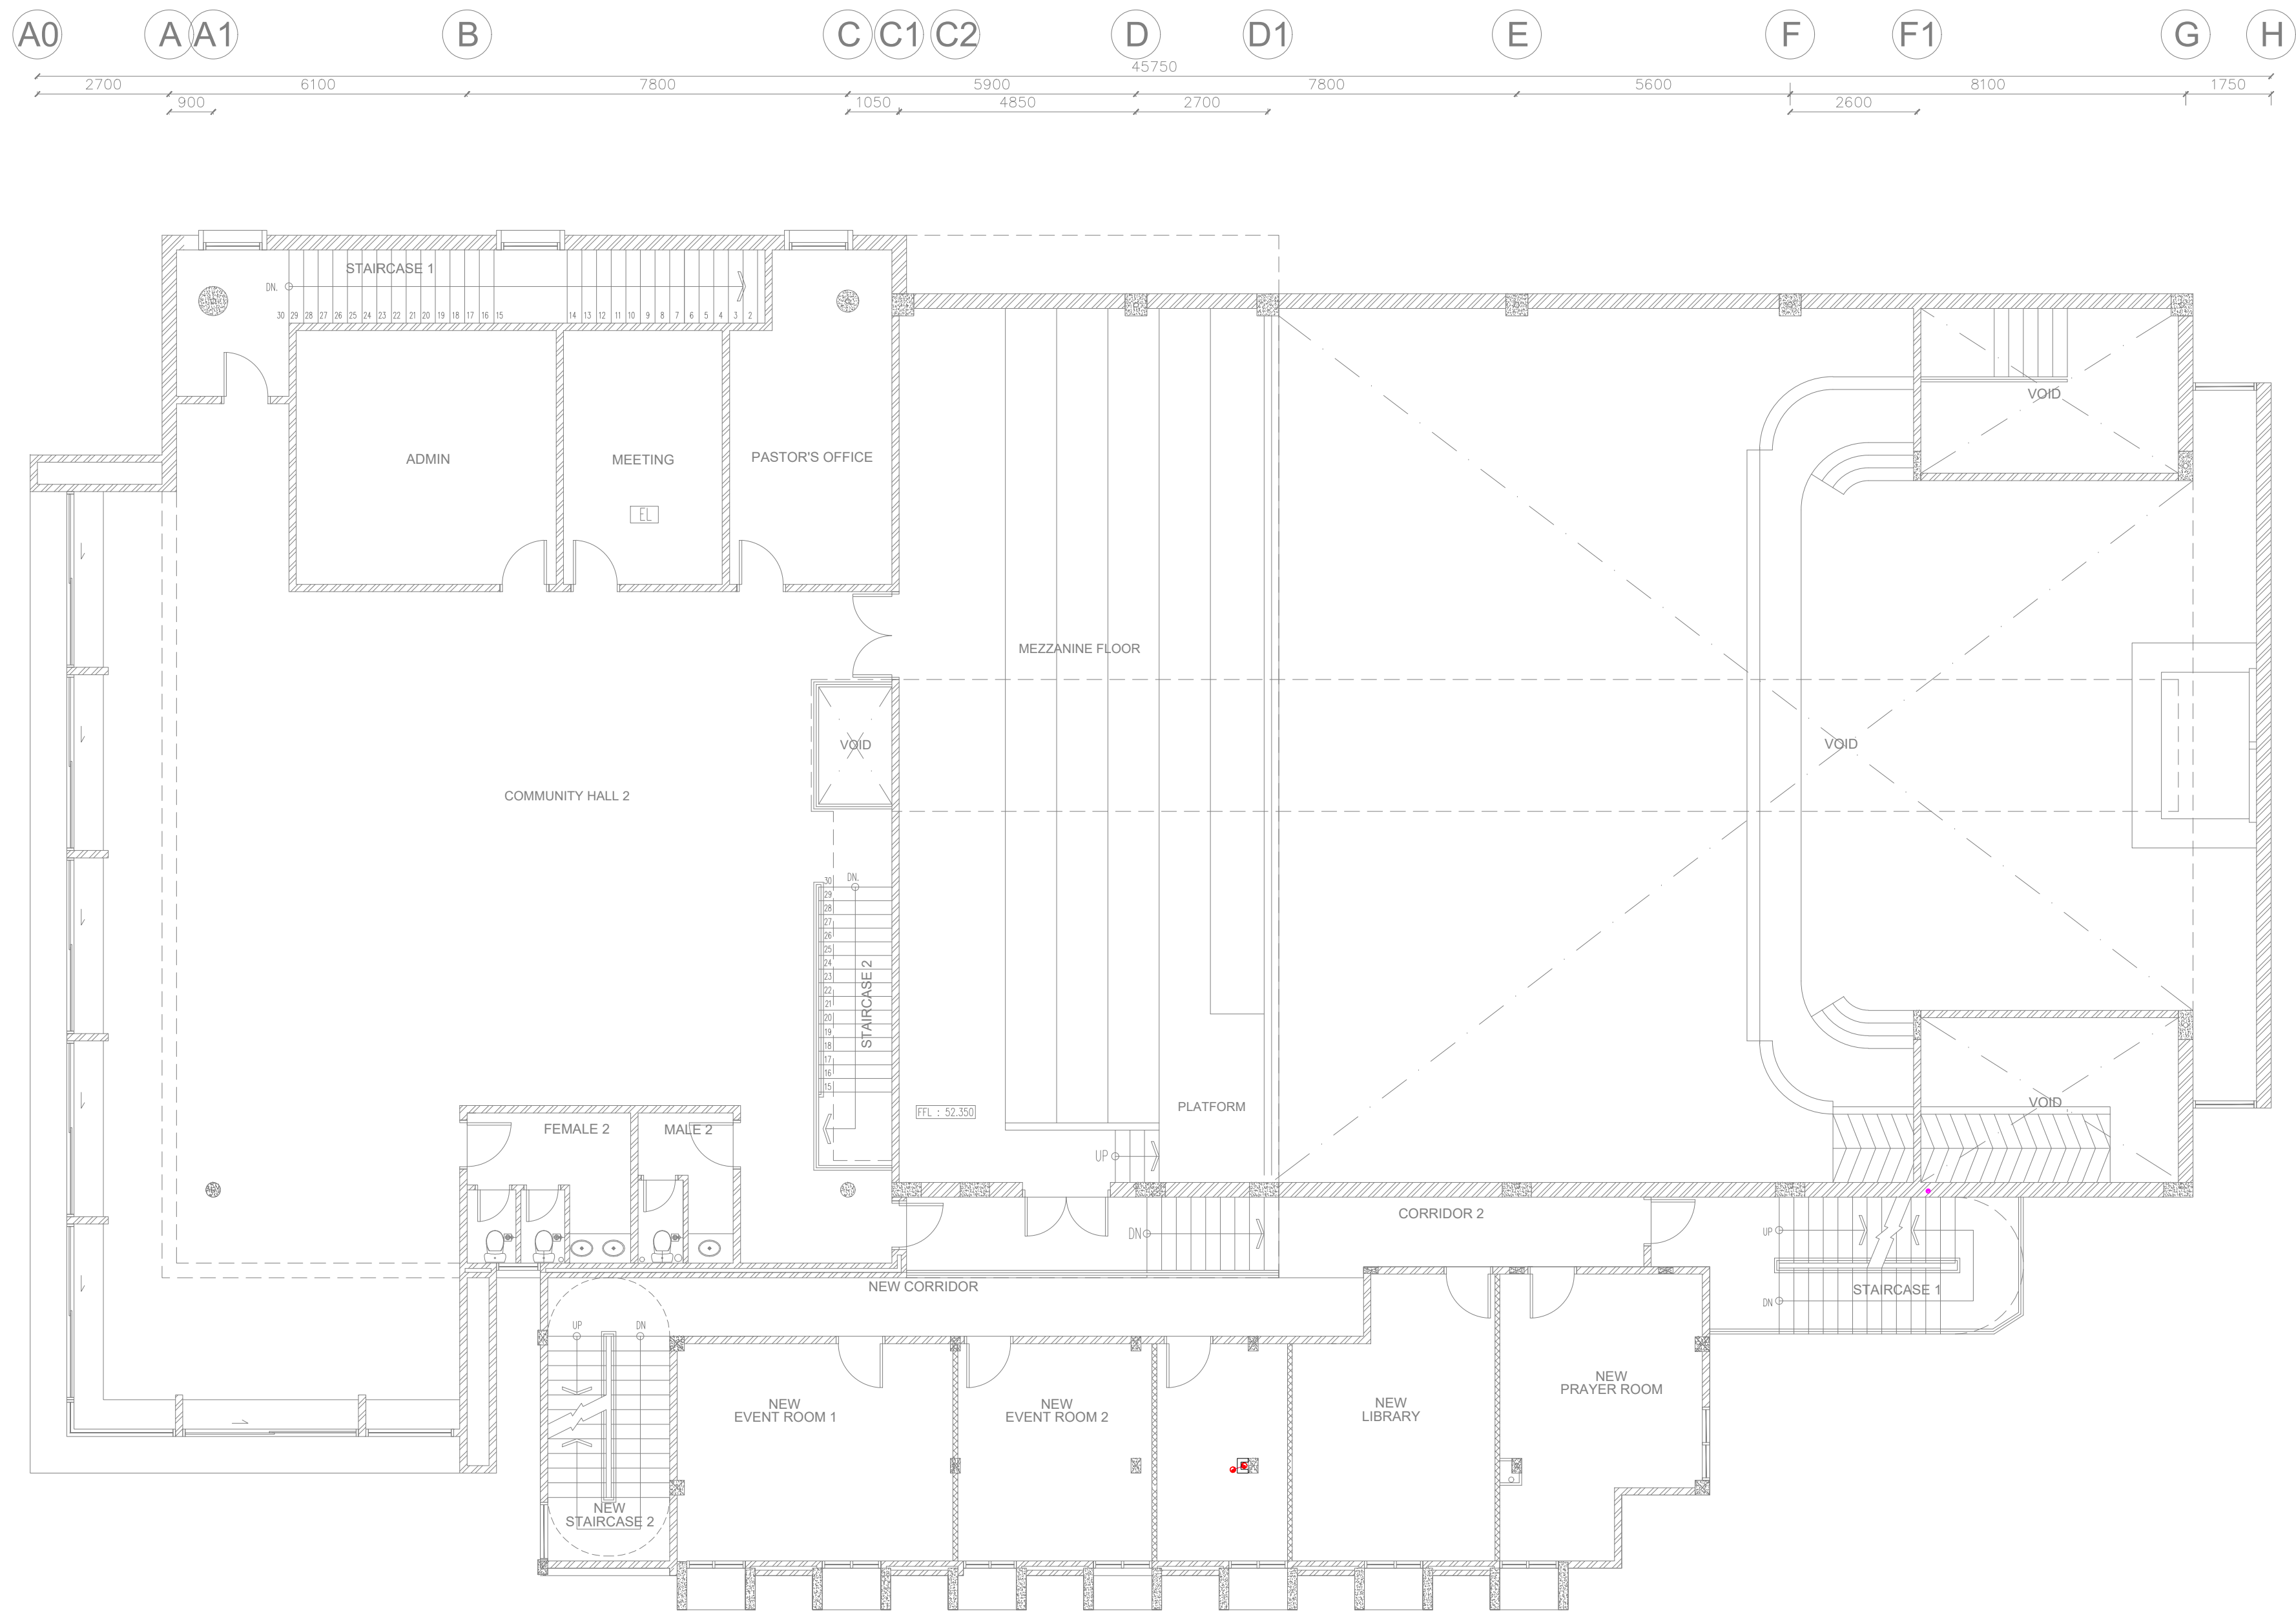

FIRST FLOOR PLAN
SCALE 1 : 200 (A3)

MAIN CONTRACTOR : NSK Construction & Engineering Sdn. Bhd. B-2-6, BBT One Boulevard Letuh Batu Nilam 2, Bandar Bukit Tinggi, 41200 Klang, Selangor Darul Ehsan. Tel : +603-3325 2328 / 2628 Fax : +603-3325 2168 E-mail: enquiry@nskce.com			
Tajuk Lukisan : FIRST FLOOR PLAN COLD WATER PIPING LAYOUT			
Tarikh : April 2023	Dilukis Oleh : Teoh		
Ukuran : 1 : 200 (A3)	Disemak Oleh : Ng		
Projek No: JCY/18043/CW-02			Bil. Lukisan : -

AS BUILT DRAWING
APRIL 2023