


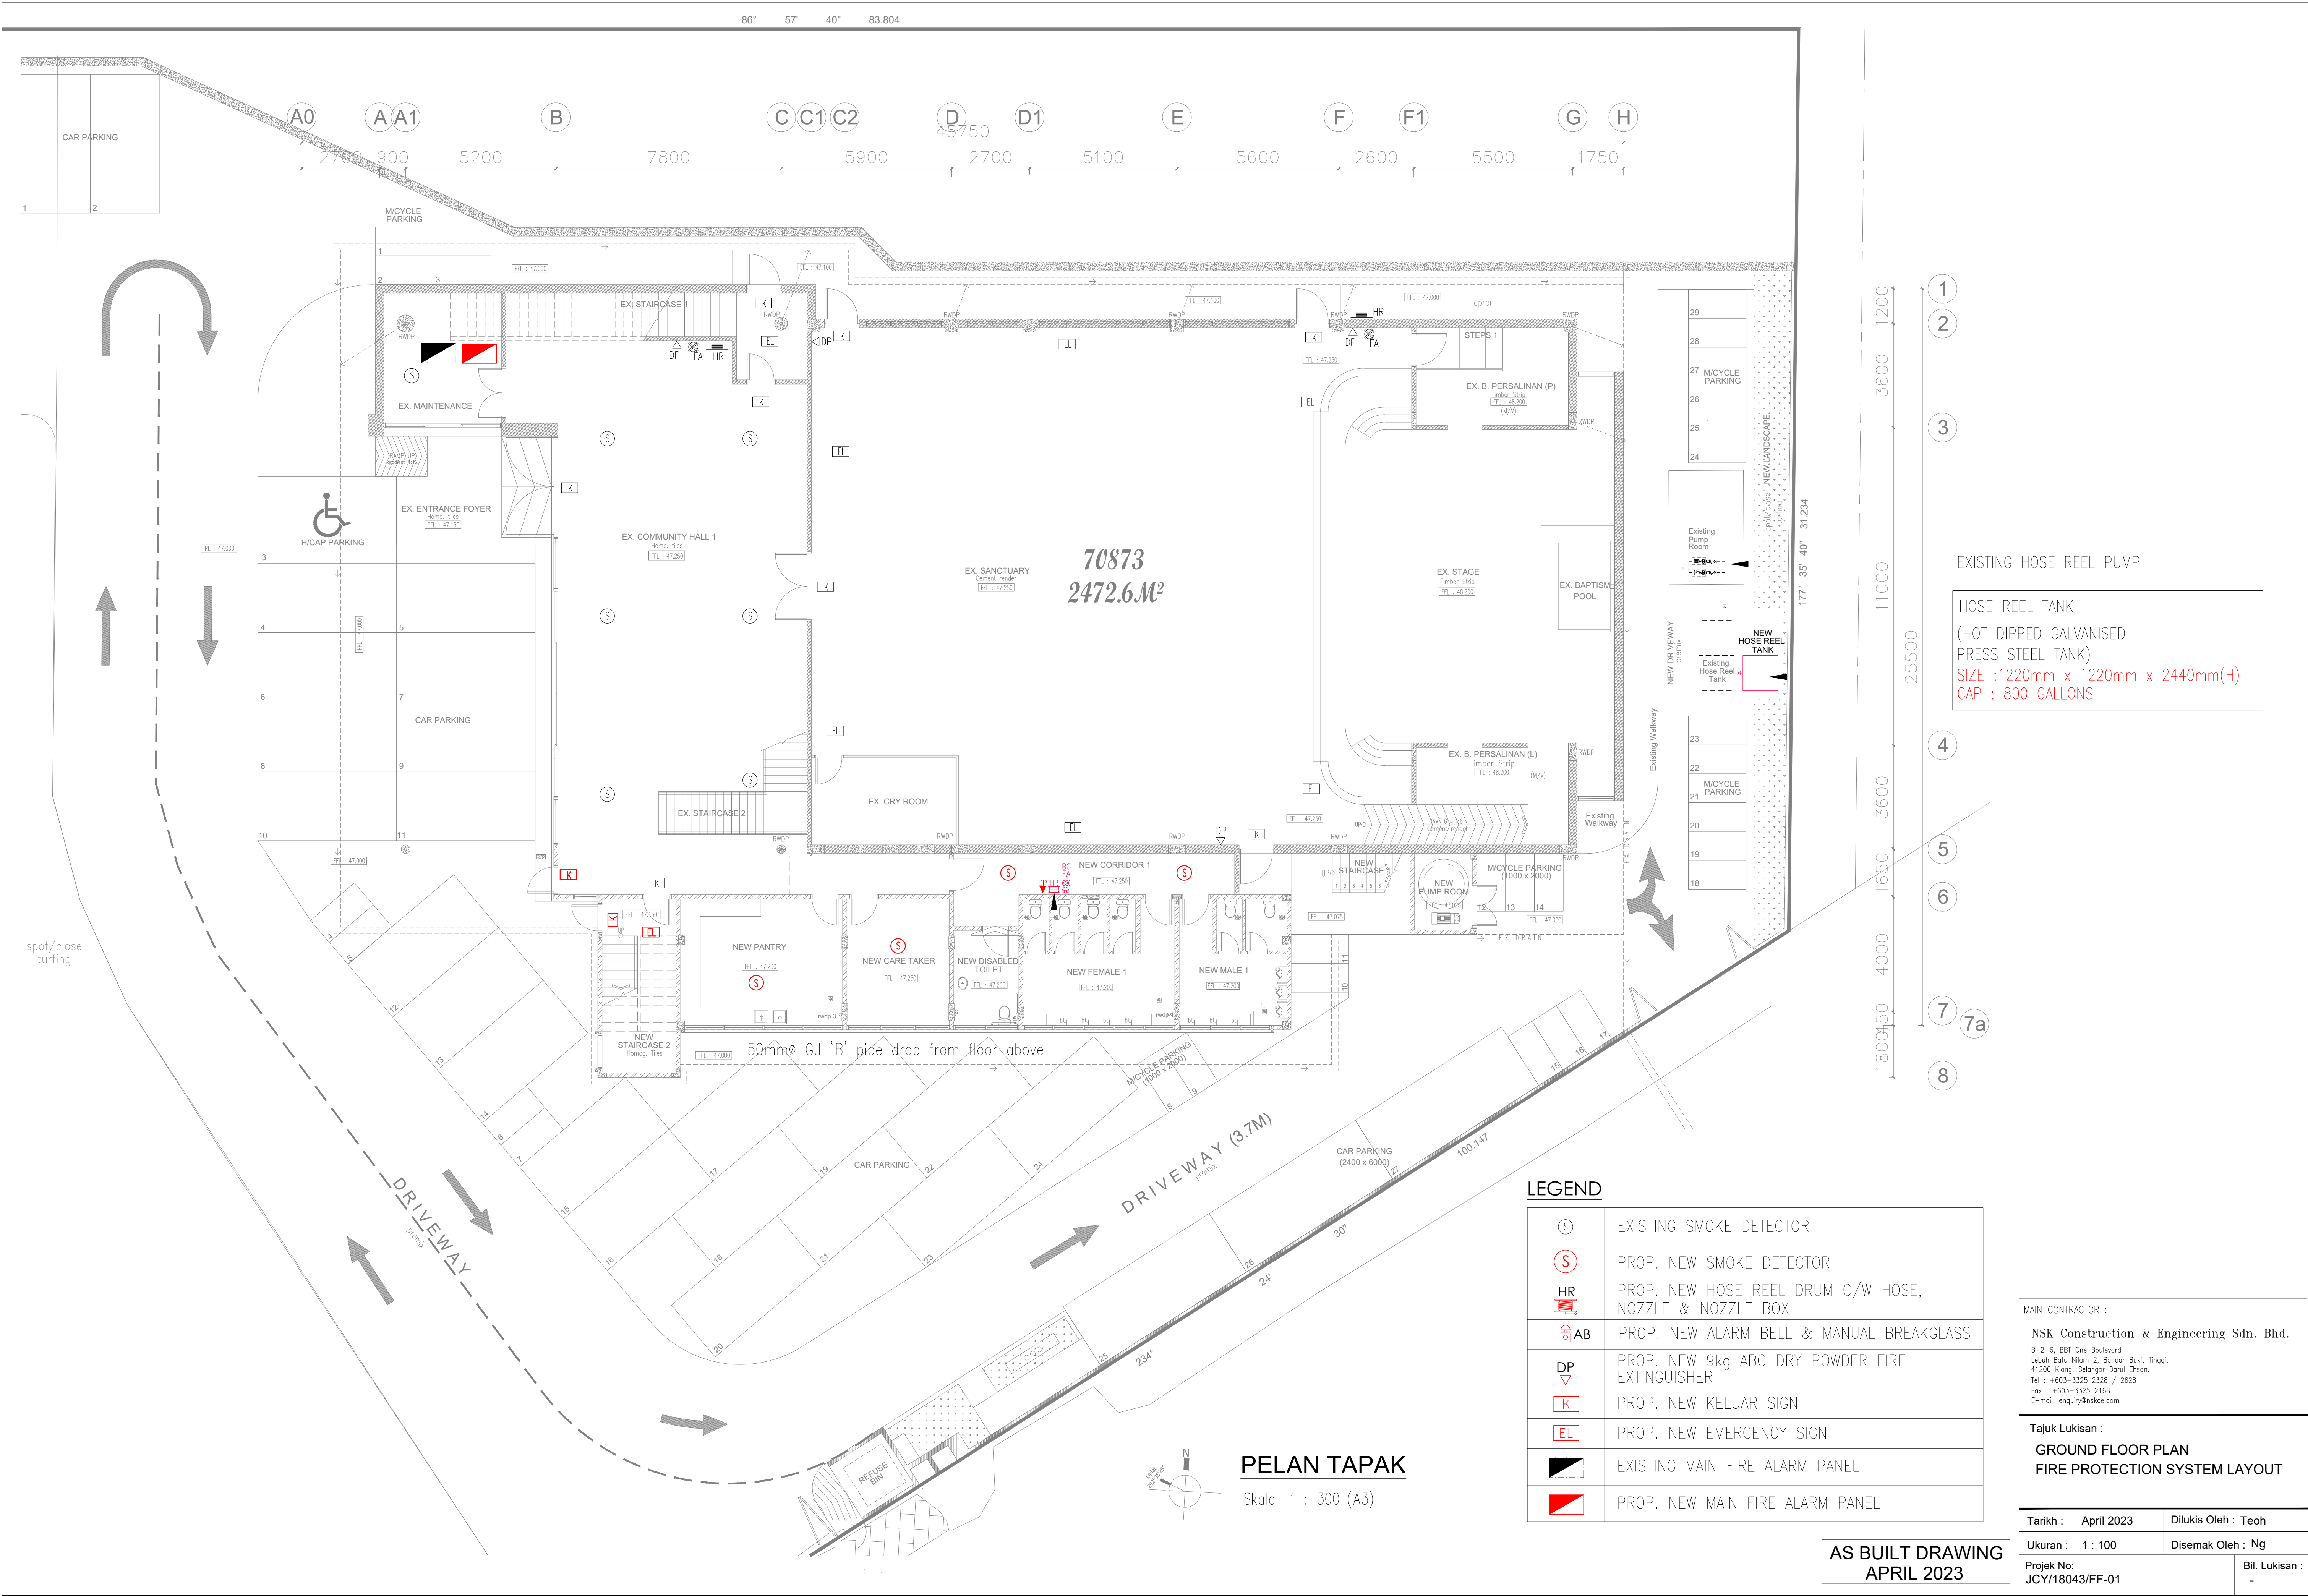

70873
2472.6M²

LEGEND

(S)	EXISTING SMOKE DETECTOR
(S)	PROP. NEW SMOKE DETECTOR
HR	PROP. NEW HOSE REEL DRUM C/W HOSE, NOZZLE & NOZZLE BOX
AB	PROP. NEW ALARM BELL & MANUAL BREAKGLASS
DP	PROP. NEW 9kg ABC DRY POWDER FIRE EXTINGUISHER
(K)	PROP. NEW KELUAR SIGN
(EL)	PROP. NEW EMERGENCY SIGN
	EXISTING MAIN FIRE ALARM PANEL
	PROP. NEW MAIN FIRE ALARM PANEL

PELAN TAPAK

Skala 1 : 300 (A3)

EXISTING HOSE REEL PUMP

HOSE REEL TANK
(HOT DIPPED GALVANISED
PRESS STEEL TANK)
SIZE :1220mm x 1220mm x 2440mm(H)
CAP : 800 GALLONS

MAIN CONTRACTOR :
NSK Construction & Engineering Sdn. Bhd.
B-2-6, BBT One Boulevard
Lebuhraya Nibong, Bandar Bukit Tinggi,
41200 Klang, Selangor Darul Ehsan,
Tel : +603-3325 2328 / 2628
Fax : +603-3325 2168
E-mail: enquiry@nskce.com

Tajuk Lukisan :
**GROUND FLOOR PLAN
FIRE PROTECTION SYSTEM LAYOUT**

Tarikh : April 2023 Dilukis Oleh : Teoh

Ukuran : 1 : 100 Disemak Oleh : Ng

Projek No:
JCY/18043/FF-01

Bil. Lukisan :
-

AS BUILT DRAWING
APRIL 2023