



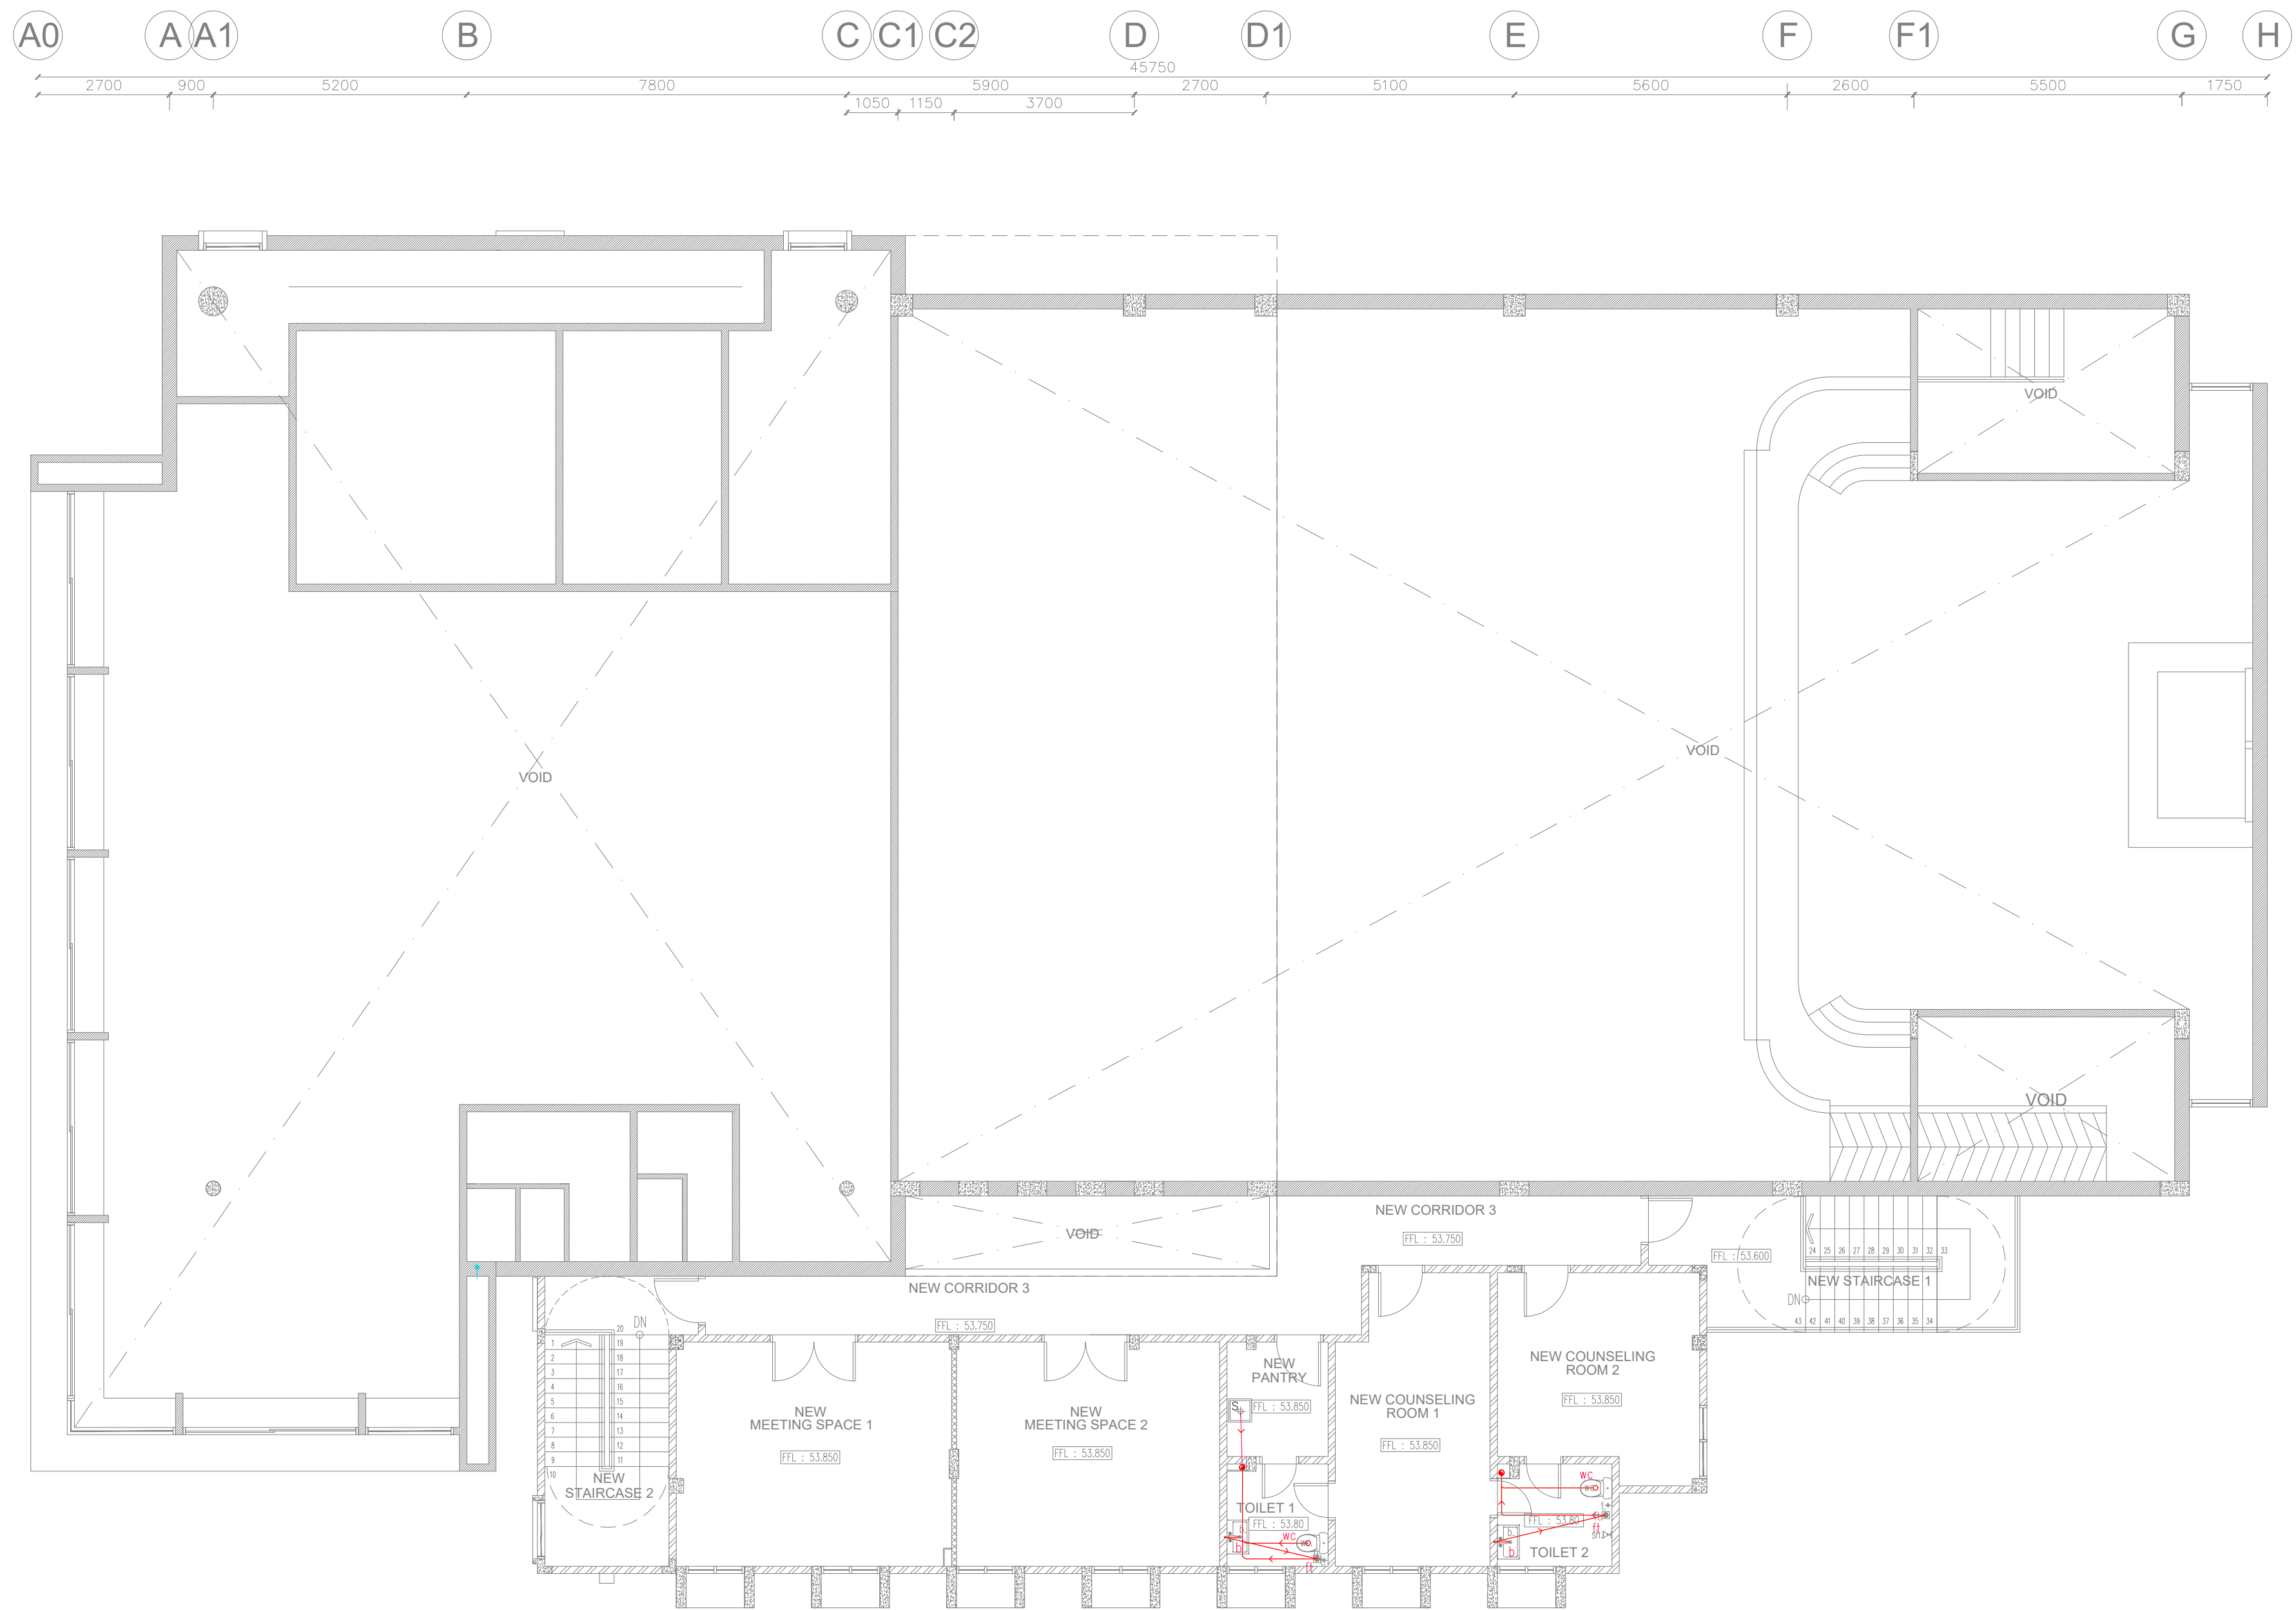

SECOND FLOOR PLAN
SCALE 1 : 200 (A3)

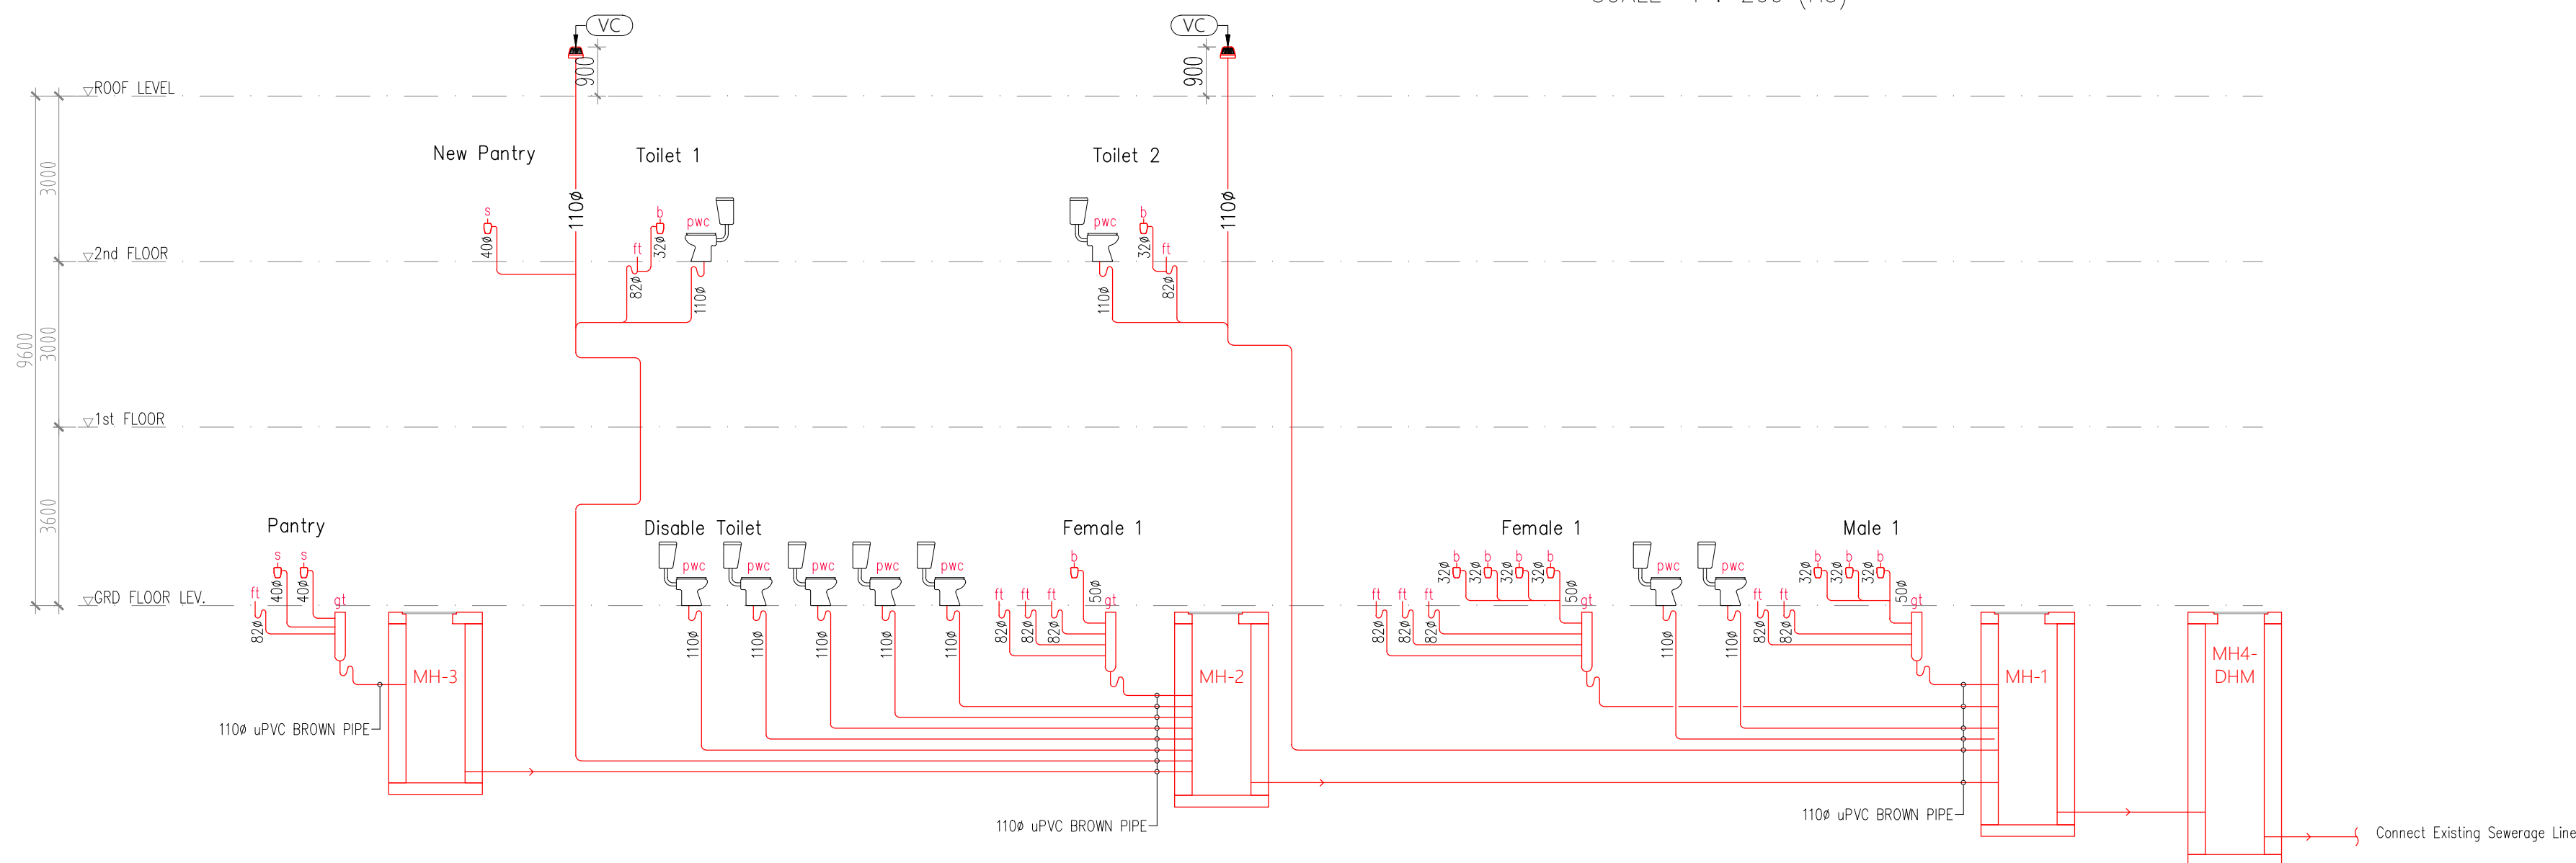

SOIL & WASTE PIPING SCHEMATIC DIAGRAM
* ALL BASIN & KITCHEN SINK C/W BOTTLE TRAP

APPLIANCE OUTLET PIPES
BS 4514 & 5255 UPVC UNLESS OTHERWISE STATED.

appliances	symbol	IN AIR		IN GROUND
		outlet dia(mm)	A.S.P dia(mm)	outlet dia(mm)
pedestal water closet		110	50	110 BROWN UPVC BS 4660
kitchen sink c/w bottle trap		40	32	40
110ø flr. gully trap & grate by plumbing nsc		80	50	80
gully trap 110ø		-	-	110 BROWN UPVC BS 4660
wash basin c/w bottle trap		32	-	32

MIN. GRADIENT OF PIPES IN GROUND

50ø	1:30
82ø	1:45
110ø	1:80
160ø	1:150

★NOTE
SANITARY PLUMBING PIPING MATERIALS

110ø : IN AIR UPVC BS 4514 & 5255
U/G BROWN UPVC BS 4660

SMALLER THAN 110ø :
ALL UPVC BS 4514 & 5255

ks : KITCHEN C/W BOTTLE TRAP
b : BASIN C/W BOTTLE TRAP
wc : WATER CLOSET
sq : SQUART WATER CLOSET
ft : 110ø FLOOR TRAP
gt : GULLY TRAP
t : TAP

AS BUILT DRAWING
APRIL 2023

MAIN CONTRACTOR :
NSK Construction & Engineering Sdn. Bhd.
B-2-6, BBT One Boulevard
Lembuh Batu Nilam 2, Bandar Bukit Tinggi,
41200 Klang, Selangor Darul Ehsan.
Tel : +603-3325 2328 / 2628
Fax : +603-3325 2168
E-mail: enquiry@nskce.com

Tajuk Lukisan :
PELAN ARAS DUA
SANITARY PIPING LAYOUT
SANITARY PIPING SCHEMATIC DIAGRAM

Tarikh : April 2023 Dilukis Oleh : Teoh

Ukuran : 1 : 100 Disemak Oleh : Ng

Projek No:
JCY/18043/SA-03

Bil. Lukisan :
-